


P&ID - Nitrous Oxide Plant

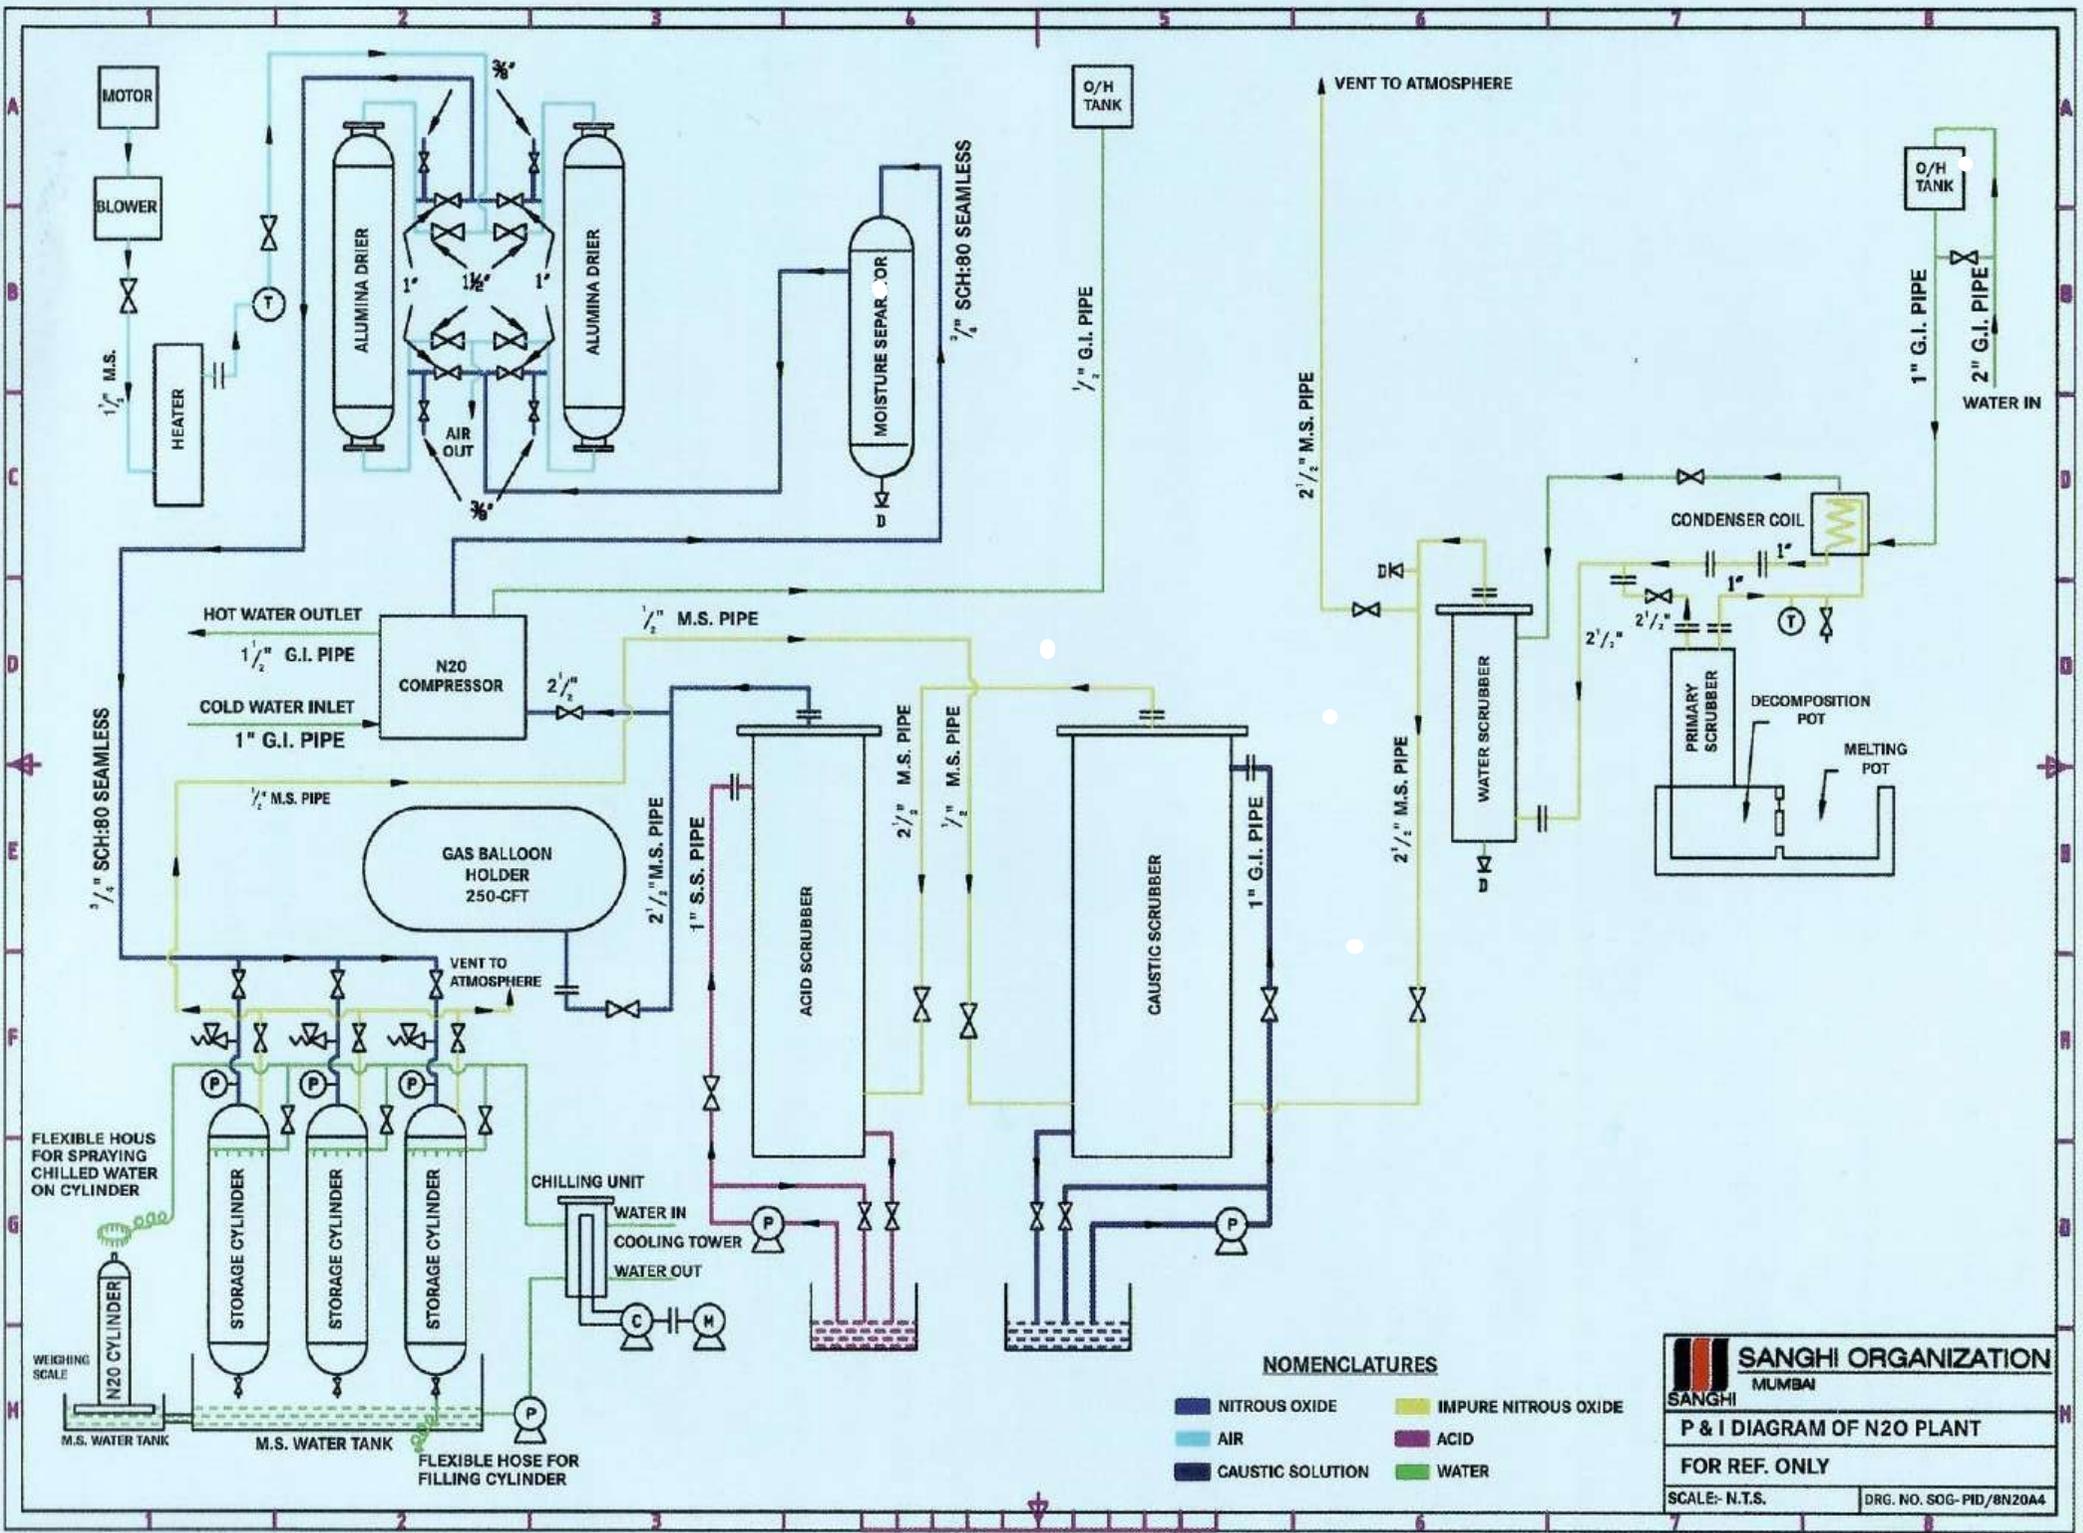

NOMENCLATURES

- NITROUS OXIDE
- AIR
- IMPURE NITROUS OXIDE
- ACID
- CAUSTIC SOLUTION
- WATER

SANGHI ORGANIZATION	
MUMBAI	
P & I DIAGRAM OF N₂O PLANT	
FOR REF. ONLY	
SCALE: N.T.S.	DRG. NO. SOG-PID/8N20A4